

Ref: NWPPL/FY26-27/RFP/Rainwater Harvesting/BWRP -02**Date:** 16.09.2026

Tender Title: Request for Proposal ("RFP") issued by NHIT Western Projects Private Limited (NWPPL) for Engagement of Agency/Firm for Civil Works for Rainwater Harvesting System at Borkhedi-Wardner project site under NWPPL.

Corrigendum I

This has reference to the subject RFP, bearing no. NWPPL/FY26-27/RFP/Rainwater Harvesting/BWRP -02, published on 09.09.2026 on NHIT website (<https://nhit.co.in/>).

1. Point 2.5. Key Dates & Milestones (Clause 1.2 of RFP) under Annexure C1 - Contract Data Sheet (CDS), of the said RFP stands revised and may be read as under:

Sl. No.	Description of Events	Subsisting schedule	Revised Schedule
1.	Bid due date (Last date for bid submission)	21.09.2026 up to 14:00 Hrs	23.09.2026 up to 15:00 Hrs
2.	Opening of Technical bids	21.09.2026 at 17:30 Hrs	23.09.2026 at 17:30 Hrs

2. Annexure C8 - Approved Drawings including layouts, GADs, and structural details, of the said RFP stands revised and enclosed herewith for the bidders.

Enclosed: Annexure C8 - Layout Plan & Drawing (Revised).

Note: Bidders are advised to take note of the above changes/updates made in the RFP while submitting their bids.

Thank you,

For and on behalf of

NHIT Western Projects Private Limited




Sandeep Khosa
GM Procurement


Borkhedi-Wadner

NOTES :-


TYPE A- RWHP PIT ALONG THE SIDE DRAIN AT EVERY 1KM ON LHS AND RHS

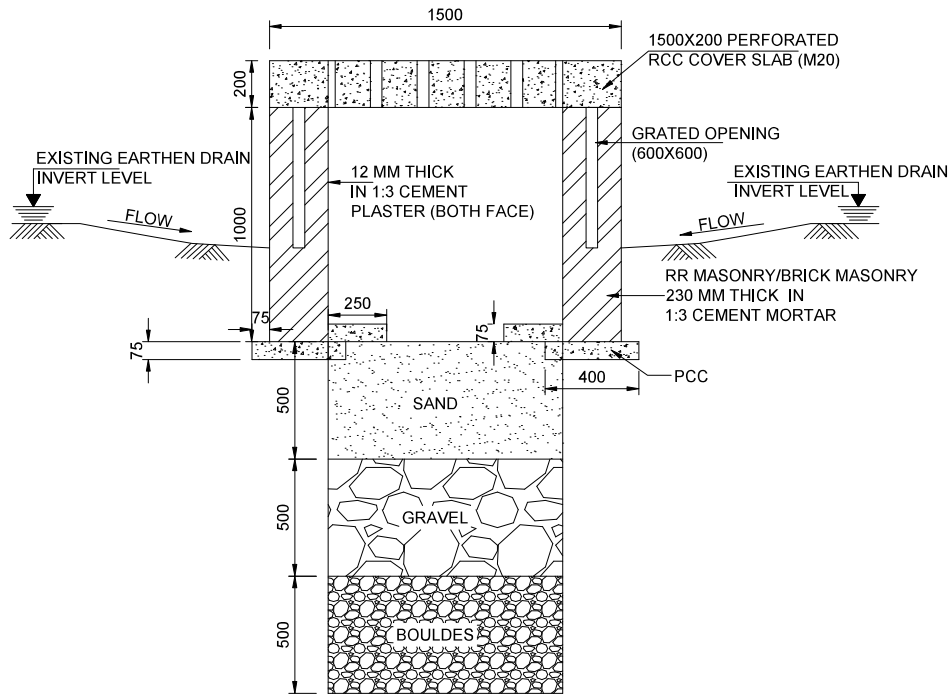

SECTION A-A

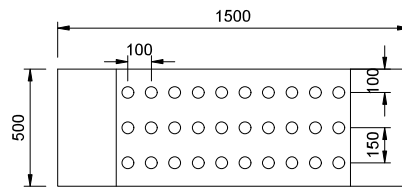


DETAIL OF PERFORATED TYPE-A

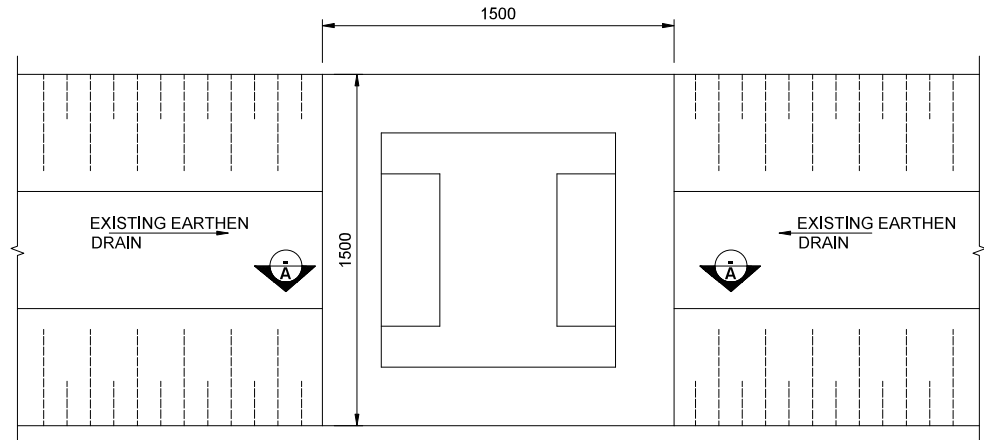

PLAN TYPE-A

 10MM ϕ @ 150MM
C/C(BOTH SIDE)



TYP. REINFORCEMENT DETAIL OF PERFORATED RCC SLAB



CLIENT :-
NHIT WESTERN PROJECTS PRIVATE LIMITED
National Highways Infra Trust

AUTHORITY ENGINEER :-
KJ K and J Projects Private Limited in association with Me MUK Infra Build Pvt. Ltd.

DESIGN CONSULTANT :-
ANV DESIGN ASSOCIATES

EPC CONTRACTOR :-
MAK Paramount Infra ventures Pvt.Ltd.
902, 9th Floor, MSX Tower-II, Alpha-4, Greater Noida (U.P.)-201308

SAFETY CONSULTANT:-
Khanna Goyal Designers LLP
T-5, 1403 Valley View Estate Gurugram, Faridabad Road, Gurugram Haryana-122003

PROOF CONSULTANT:-
Saarthi International Pvt. Ltd.
First Floor, 1734A, Housing Board, Sector 31, Gurugram, Haryana - 122001

APPROVED BY: _____
CHECKED BY: _____
DESIGNED BY: _____
DRAWN BY: _____
SCALE: AS SHOWN
DATE: MARCH - 2025

PROJECT:
Construction of VUP and widening of MNB structure including widening of Culverts and other works in Borkhedi-Wadner-Kelapur Project from km 36+600 to 175+000 section on NH-44 in the State of Maharashtra, Engineering, Procurement & Construction (EPC) Mode.

TITLE:
TYPICAL DETAIL OF RAINWATER HARVESTING
DRG NO.: NHIT/_/RWHP/GAD/01

DATE	REV	BY	DESCRIPTION OF REVISIONS
17.04.2025	00	G.S.	INITIAL DRAWING